


THE INFORMATION CONTAINED IN THIS DRAWING IS THE SOLE PROPERTY OF L-COM, INC. ANY REPRODUCTION IN PART OR WHOLE WITHOUT THE WRITTEN PERMISSION OF L-COM, INC. IS PROHIBITED.

REVISIONS			
REV	DESCRIPTION	DATE	APPROVED
A	INITIAL RELEASE	7/15/03	DFP
B	ECN1441: CHANGE MODEL SERIES NUMBER IN TABLE	7/25/03	DFP
C	ECN1518: CHANGED GENDER OF MINI-DINS ON "J1" END	9/25/03	DFP

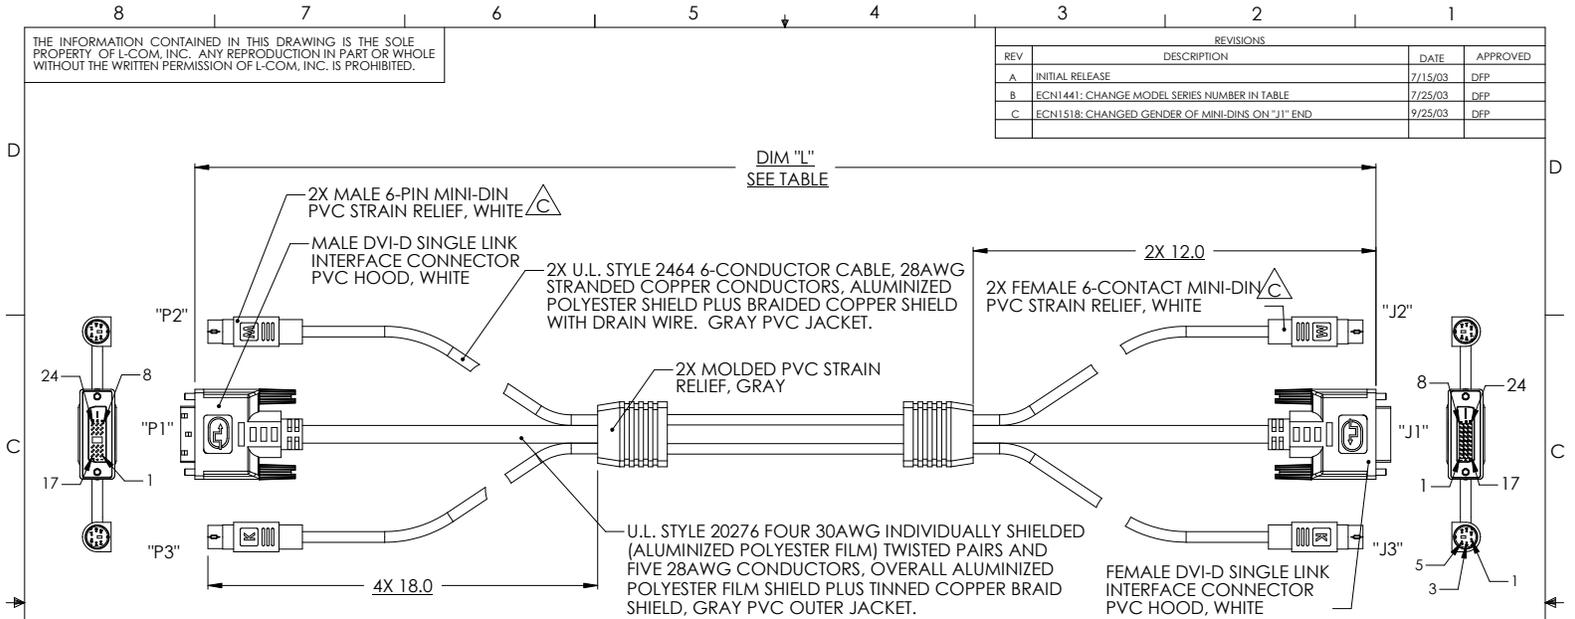


WIRE CHART			
"P1"	"J1"	PAIRING	FUNCTION
PIN 19	PIN 19		PAIR 0 GROUND
PIN 18	PIN 18	PAIR 1	TX0+
PIN 17	PIN 17		TX0-
PIN 10	PIN 10	PAIR 2	TX1+
PIN 9	PIN 9		TX1-
PIN 11	PIN 11		PAIR 1 GROUND
PIN 15	PIN 15		LOGIC GROUND
PIN 14	PIN 14		PLUS 5V DC
PIN 2	PIN 2	PAIR 3	TX2+
PIN 1	PIN 1		TX2-
PIN 3	PIN 3		PAIR 2 GROUND
PIN 22	PIN 22		PAIR 4 GROUND
PIN 23	PIN 23	PAIR 4	TXC+
PIN 24	PIN 24		TXC-
PIN 16	PIN 16		HPD
PIN 7	PIN 7		DDC SBA
PIN 6	PIN 6		DDC SCL
SHELL	SHELL		SHIELD DRAIN WIRE

MODEL	DIM "L"	
	METERS	FEET
CTLKVMDFIF-2	2	6.6
CTLKVMDFIF-3	3	9.8
CTLKVMDFIF-5	5	16.4

MINI-DIN "M" WIRING TABLE		MINI-DIN "K" WIRING TABLE	
"P2" MINI DIN 6	"J2" MINI DIN 6	"P3" MINI DIN 6	"J3" MINI DIN 6
1	1	1	1
2	2	2	2
3	3	3	3
4	4	4	4
5	5	5	5
6	6	6	6
SHIELD	SHIELD	SHIELD	SHIELD

UNLESS OTHERWISE SPECIFIED DIMENSIONS ARE IN INCHES TOLERANCES ARE:
 .XX ±.01
 .XXX ±.005
 CABLE LENGTH TOLERANCE
 <300' ±5% >300' ±2%

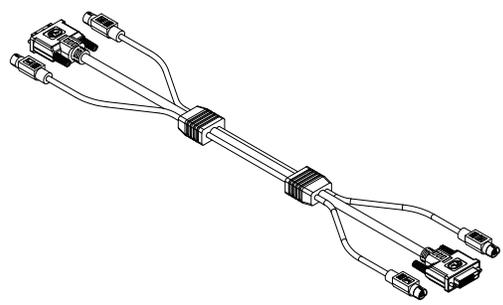

APPROVALS	DATE
DRAWN BY D. PARHAM	7/3/2003
CHECKED BY B. MAZEJKA	7/3/2003
APPROVED BY C. McCORMICK	7/3/2003

L-com 45 BEECHWOOD DRIVE
 NORTH ANDOVER, MA 01845

PRODUCT DESCRIPTION: DVI-D KVM CABLE

DRAWING TITLE: OUTLINE DRAWING

SIZE: **A** FSCM NO.: 43321 DWG. NO.: CTLKVMDFIF-2-OD1

SCALE: NONE CAD FILE: CTLKVMDFIF-2-OD1.SLDRW SHEET 1 OF 1